



PWGC
Strategic Environmental and Engineering Solutions

P.W. GROSSER CONSULTING ENGINEER AND HYDROGEOLOGIST, P.C.

630 Johnson Avenue • Suite 7
Bohemia • NY • 11716-2818
Phone: (631) 526-6500 / 589-8705
Email: INVO@PWGROSSER.COM


CONSULTANTS

1	Revisions for Town Planning	11/24/13
2	Revisions for Town Planning	3/15/15
3		
4		
5		
6		
7		

WATERMILL VILLAGE TOWNHOUSES
PLANNED DEVELOPMENT DISTRICT
WATERMILL, NY

SUFFOLK COUNTY, NY

PRELIMINARY LAYOUT
OF WATER AND SEWER
APPURTENANCES

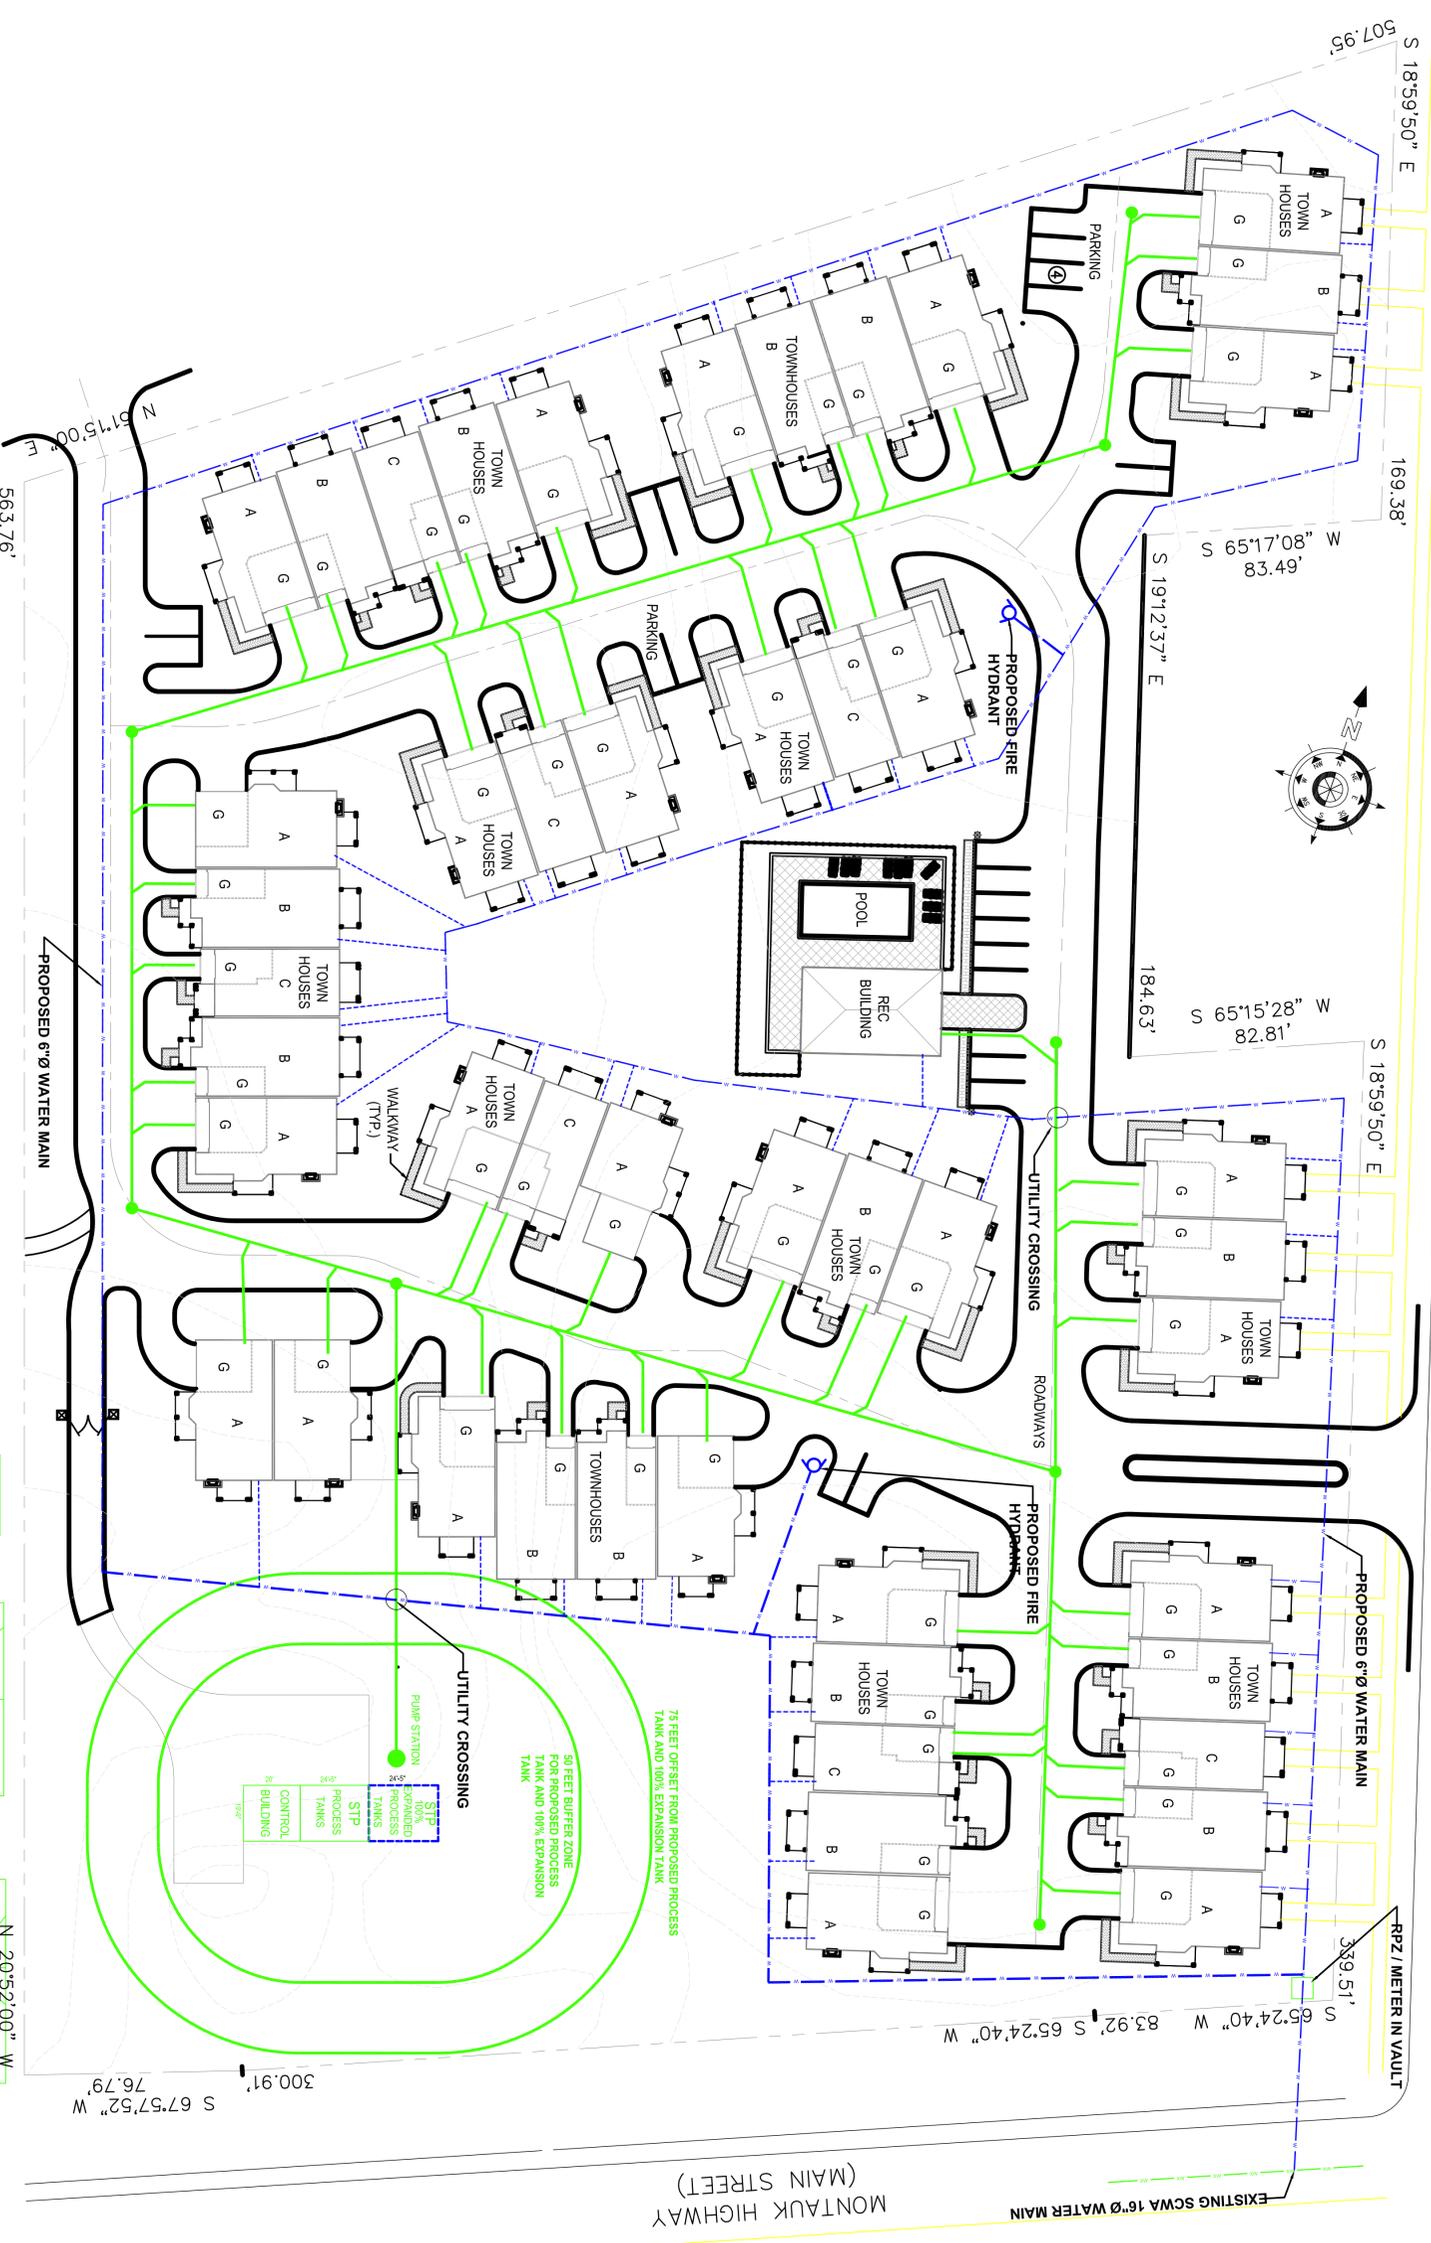

PRELIMINARY SITE PLAN

SCALE: 1" = 30'-0"

PWGC FILE NAME: J:\Projects 5-20\0001101\Report\CD\Water service PLAN 11-4-13.dwg (Last) PLOT DATE/TIME: Jan 19, 2014 4:41pm By: rose